

GENERAL NOTES:

- 1. FIXTURES, EQUIPMENT AND PIPING LOCATIONS SHOWN FROM BEST AVAILABLE INFORMATION. CONTRACTOR SHALL FIELD VERIFY SIZES, CONDITION AND LOCATIONS.
- 2. FIXTURES/EQUIPMENT THAT IS BEING REMOVED SHALL BECOME THE PROPERTY OF THE CONTRACTOR AND SHALL BE REMOVED FROM THE JOB SITE, EXCEPT EQUIPMENT SELECTED BY OWNER. CONTRACTOR TO COORDINATE FIXTURE/EQUIPMENT OWNERSHIP WITH OWNER PRIOR TO COMMENCING WORK. OWNER SELECTED FIXTURES/EQUIPMENT WILL BE TAGGED AND SHALL BE MOVED BY CONTRACTOR TO
- WHERE PIPING IS TO BE CUT OFF AT A POINT, IT SHALL BE CAPPED OR BLANKED OFF AT THAT POINT. INSULATION ON REMAINING PIPE TO BE REPAIRED TO NEW CONDITION.
- 4. PIPING CONNECTED TO FIXTURES/EQUIPMENT THAT IS BEING REMOVED SHALL BE CUT AND CAPPED IN WALLS, FLOORS OR CEILING SO AS NOT TO INTERFERE WITH NEW CONSTRUCTION OR EQUIPMENT. 5. CONTRACTOR TO COORDINATE WHAT TIME OF DAY THE WORK IS TO OCCUR, HOW MANY SHIFTS PER
- DAY, IF WEEKENDS, NIGHTS, HOLIDAYS ARE REQUIRED PRIOR TO SUBMITTING BID. 6. CONTRACTOR TO GIVE WRITTEN NOTIFICATION OF ANY INTERRUPTION OF SERVICES A MINIMUM OF
- 7. CONTRACTOR TO CROSS-REFERENCE AND VERIFY ALL FOOD SERVICE EQUIPMENT REQUIREMENTS WITH PRODUCT DATA PRIOR TO COMMENCING ROUGH-INS.
- 8. CONTRACTOR TO COORDINATE MAINTAINING CONTINUITY OF EXISTING SYSTEMS DURING CONSTRUCTION, PRIOR TO COMMENCING WORK.

SHEET NOTES:

- 1. REFER TO SHEET 120-P-112E FOR CONTINUATION.
- 2. REFER TO SHEET 120-P-132E FOR CONTINUATION.
- 3. AVOID ROUTING NEW WASTE PIPING WITHIN ELECTRICAL ROOM BELOW.
- 4. CONNECT 1/2" HWR TO HW THRU BALL VALVE AND CIRCUIT SETTER.
- 5. CW/HW DOWN IN WALL, AND ROUTE HEADER WITHIN CHASE.

HARRAH'S NOLA CIP **AREA E RESTROOMS (120)**

Jazz Casino Company LLC Harrah's Casino 8 Canal Street New Orleans, Louisiana 70130 Project Director: Ryan Worrell


JCJARCHITECTURE

6847 PONDEROSA WAY SUITE 100 LAS VEGAS, NV 89118 702.577.2650


© 2022 JCJ Architecture



Las Vegas, NV 89123 T. (702) 896-1100 msa-ec.com L21106

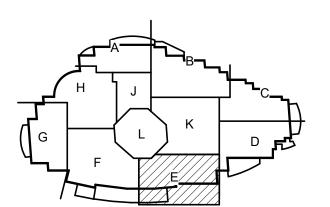

BULLETIN 120-03 10/12/2022

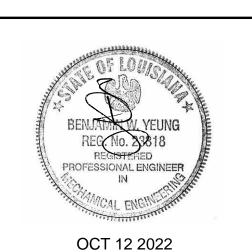


ISSUE __6/06/2022

DRAWN Author SCALE ___1/4" = 1'-0"

01 7/15/2022 BULLETIN 120-01 03 10/12/2022 BULLETIN 120-03

ENLARGED PLUMBING PLANS - FOH RESTROOMS

120-P-420

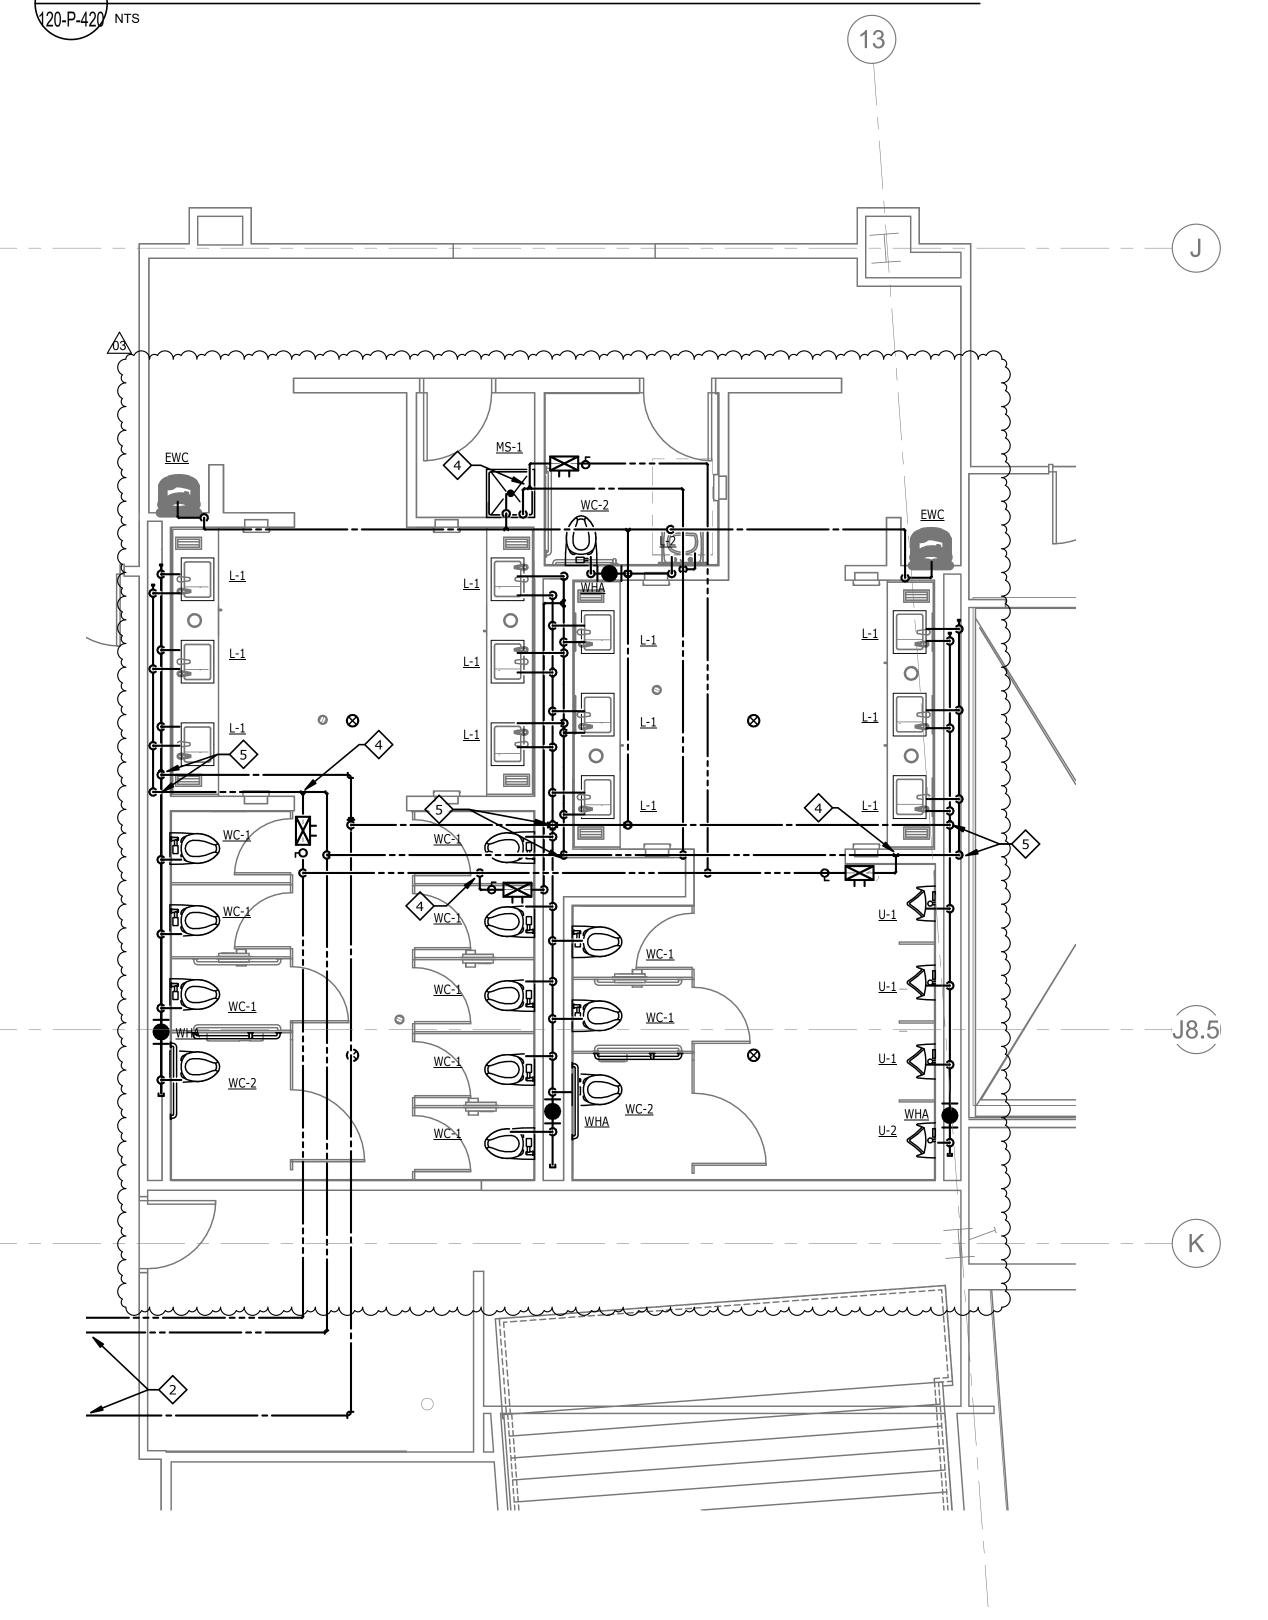

120-AREA E RESTROOM - DOMESTIC WATER



120-P-420 1/4" = 1'-0"

munity further the second seco

120-AREA E RESTROOM - WASTE AND VENT





REVISED ENTIRE SHEET